

VEHICULAR EGRESS

11

DD

DD

TBM
RL = 19.29

ROAD CENTRELIN

CAPRIC

TPS

EXIST. DWELLING
ROOF

40,4

GERALDTON
LICENCE NO.
304050

RALDTON-GREENOUGH
 LICENSE NO. 304050
 DATE 05 AUG 2010


SIGHTED

LEGEND


① TYPICAL 1800 ϕ x 1200mm EFFECTIVE DEPTH SOAKWELL

CGG Copy
KWEILL

1. TYPICAL. 1800W x 1200mm EFFECTIVE DEPTH SOAKWELL REFER TO DETAIL.
2. TYPICAL. GALVANISE PRECAST CONCRETE SHIM BOX WITH GRATE UNDER EACH DOWN PIPE. REFER TO DETAIL.
3. TYPICAL. 1800W x 1200mm EFFECTIVE DEPTH SOAKWELL WITH GRATE. REFER TO DETAIL TO BE 200mm BELOW GROUND LEVEL. REFER TO DETAIL.
4. 500W PVC BETWEEN SOAKWELLS. REFER TO STORMWATER SITE PLAN FOR CONTINUATION.
5. 500W PVC CARPET IN CAST IRON BOX AT GROUND LEVEL. INSTALL AT LEVEL TO SUIT CONNECTION BETWEEN STAGE 1 SOAKWELL AND FUTURE SOAKWELLS. APPROXIMATELY 600mm BELOW DRIVEWAY, REFER TO SOAKWELL DETAIL FOR INTENDED CONNECTIONS.
6. 1000W PVC CARPET IN CAST IRON BOX AT GROUND LEVEL FOR FUTURE CONNECTION OF LIGHT DOWN PIPES. INSTALL AT APPROXIMATELY 600mm BELOW DRIVEWAY.

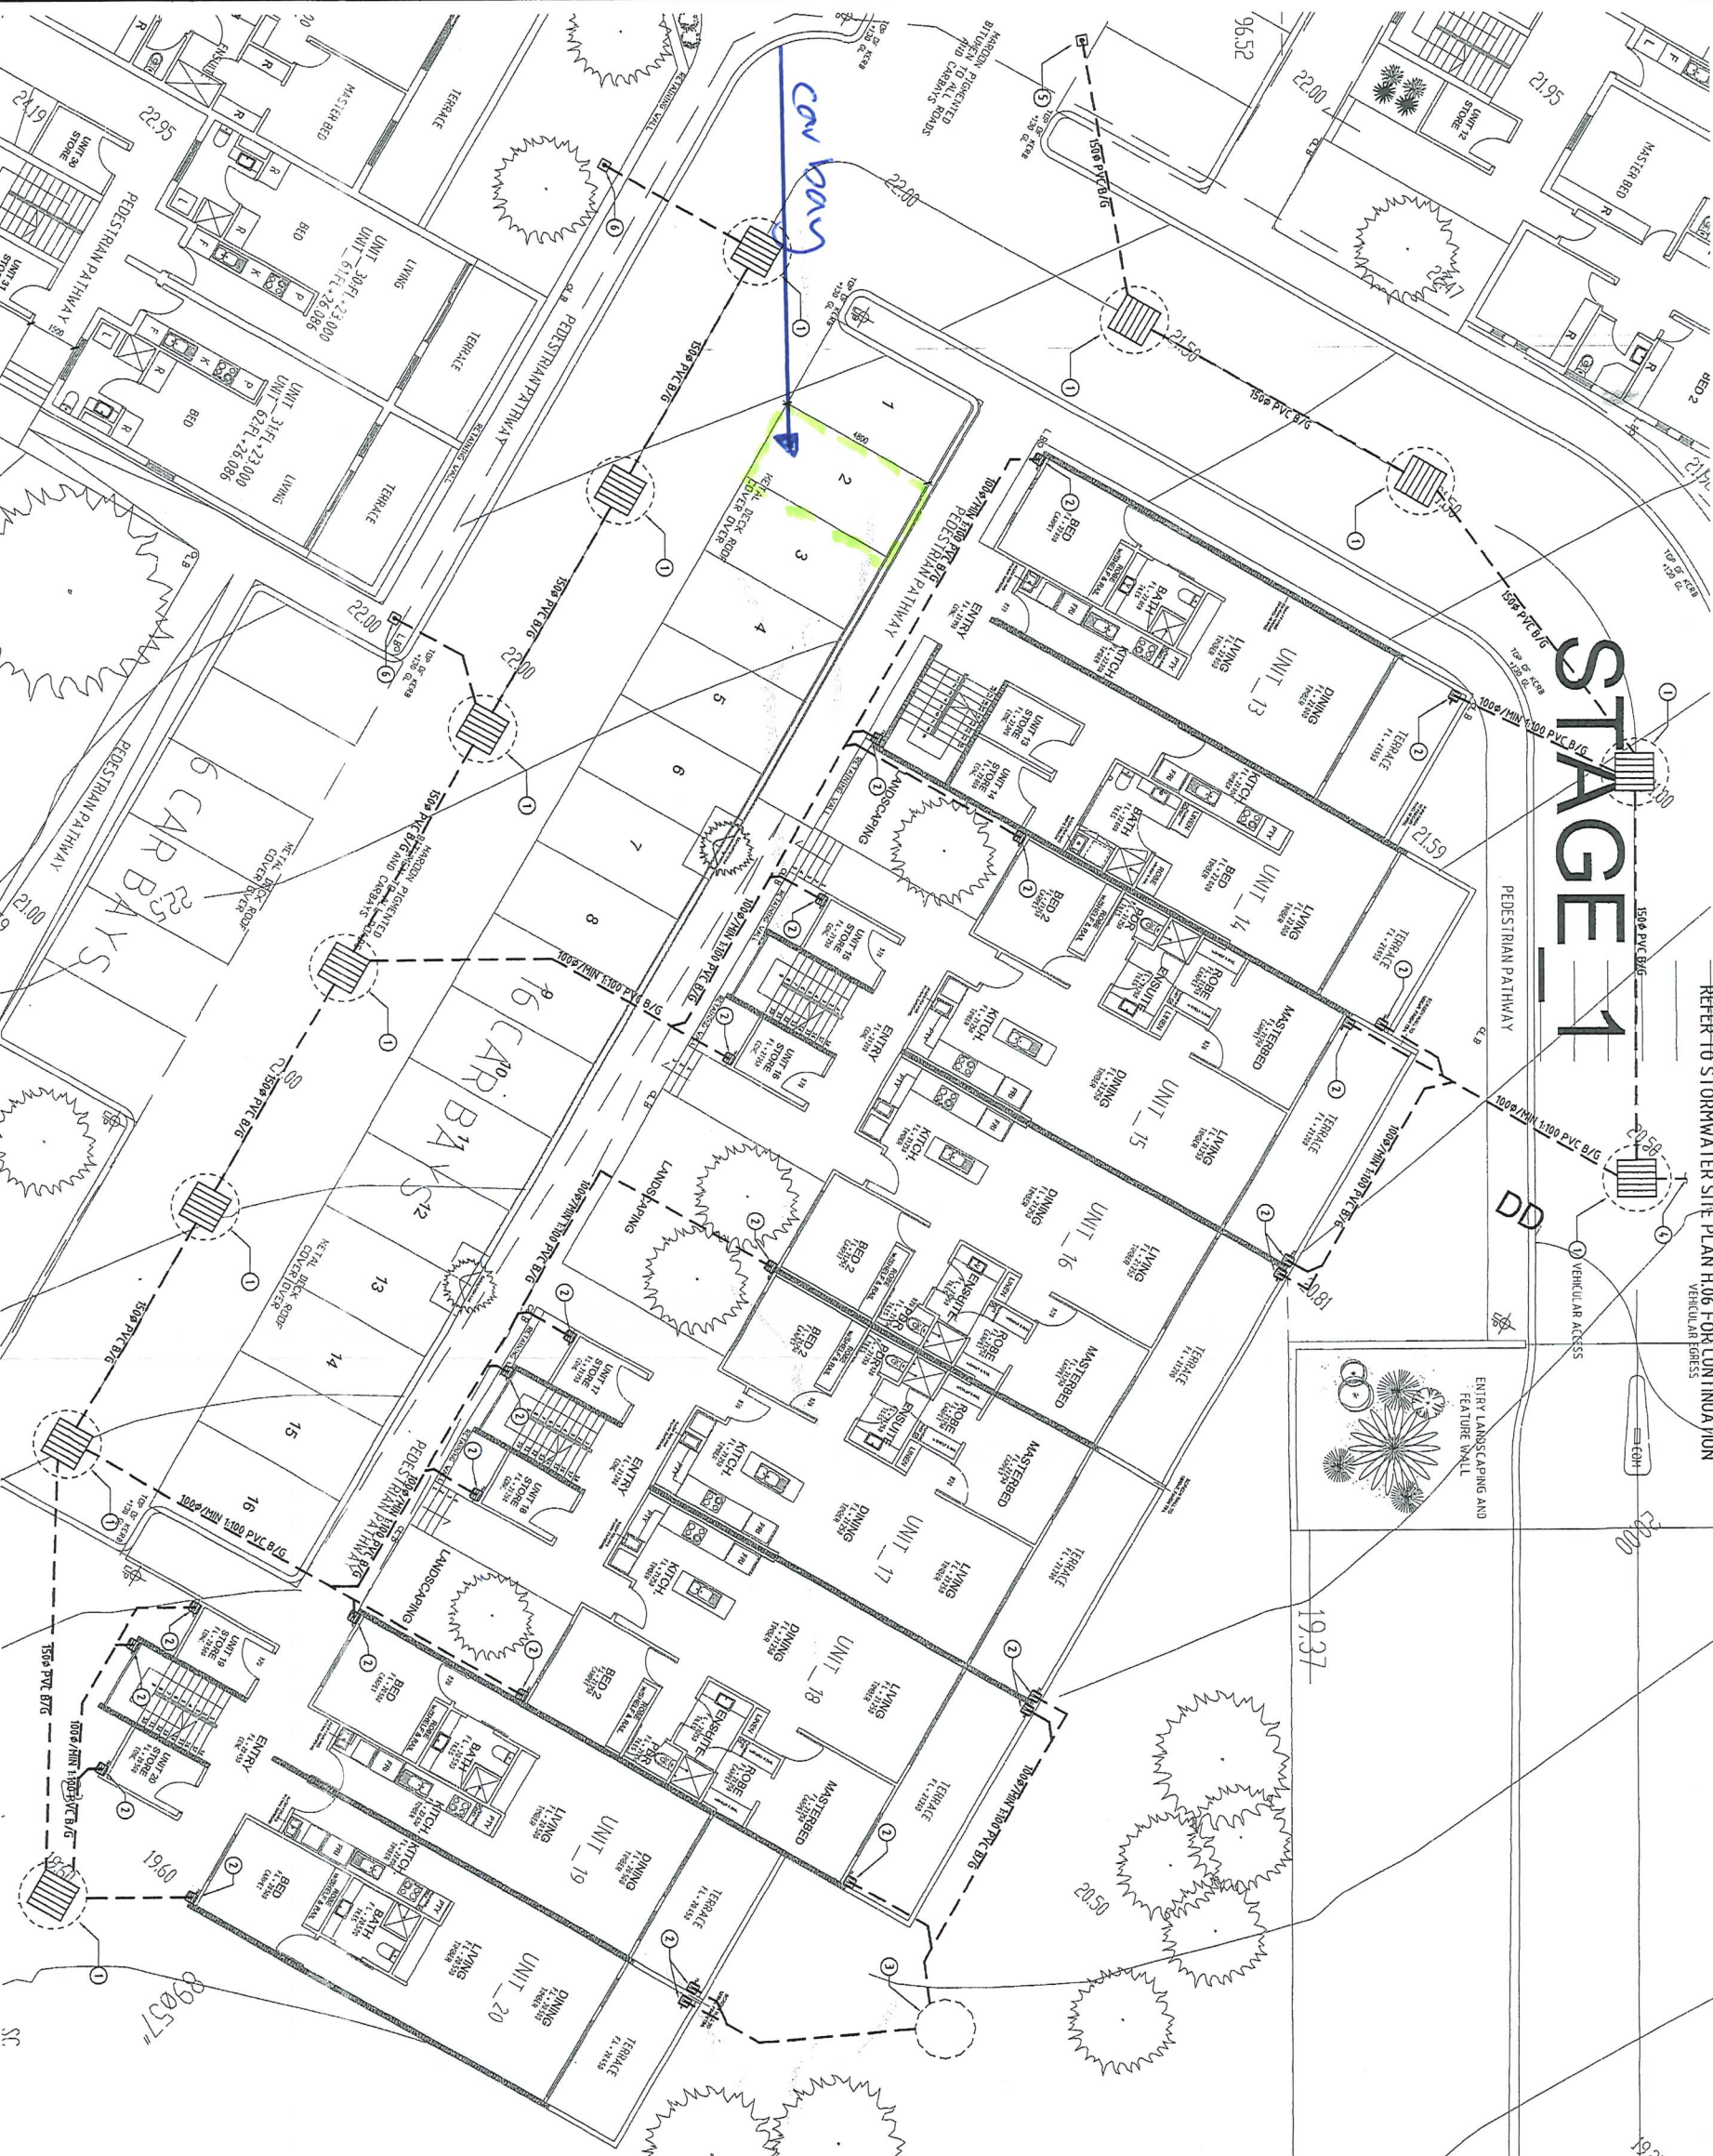

NO. DATE		AMENDMENT		CHKD		NO. DATE		AMENDMENT		CHKD		CONSULTANTS:	
												STRUCTURAL	
												ELECTRICAL	
												HYDRAULIC	
												WILUPPTON + PARTNERS	
												MECHANICAL	
DESIGN AND DOCUMENTATION BY:													
ross mcdonald architects													
2 / 5 Centro Avenue Subiaco 6008 Western Australia													
Telephone: (08) 6380 2723													
Facsimile: (08) 6380 2877													
P T Y L T D													
JOB: GERALDTON APARTMENTS													
ADDRESS: LOT 151 & 27 CARPICE RD. GERALDTON													
CLIENT: WESTBEST PTY LTD													
DWG: STAGE 1 STORMWATER LAYOUT													
													
SCALE		DATE CREATED		DRAWING No.		CHECKED							
1:100		300 Mm		090114		H.05							
ISSUED FOR:		DATE REVISION		TIME									
BL													
TEL. NAME													
THIS IS A CAD DRAWING AND NOT ASSED MANUALLY.													

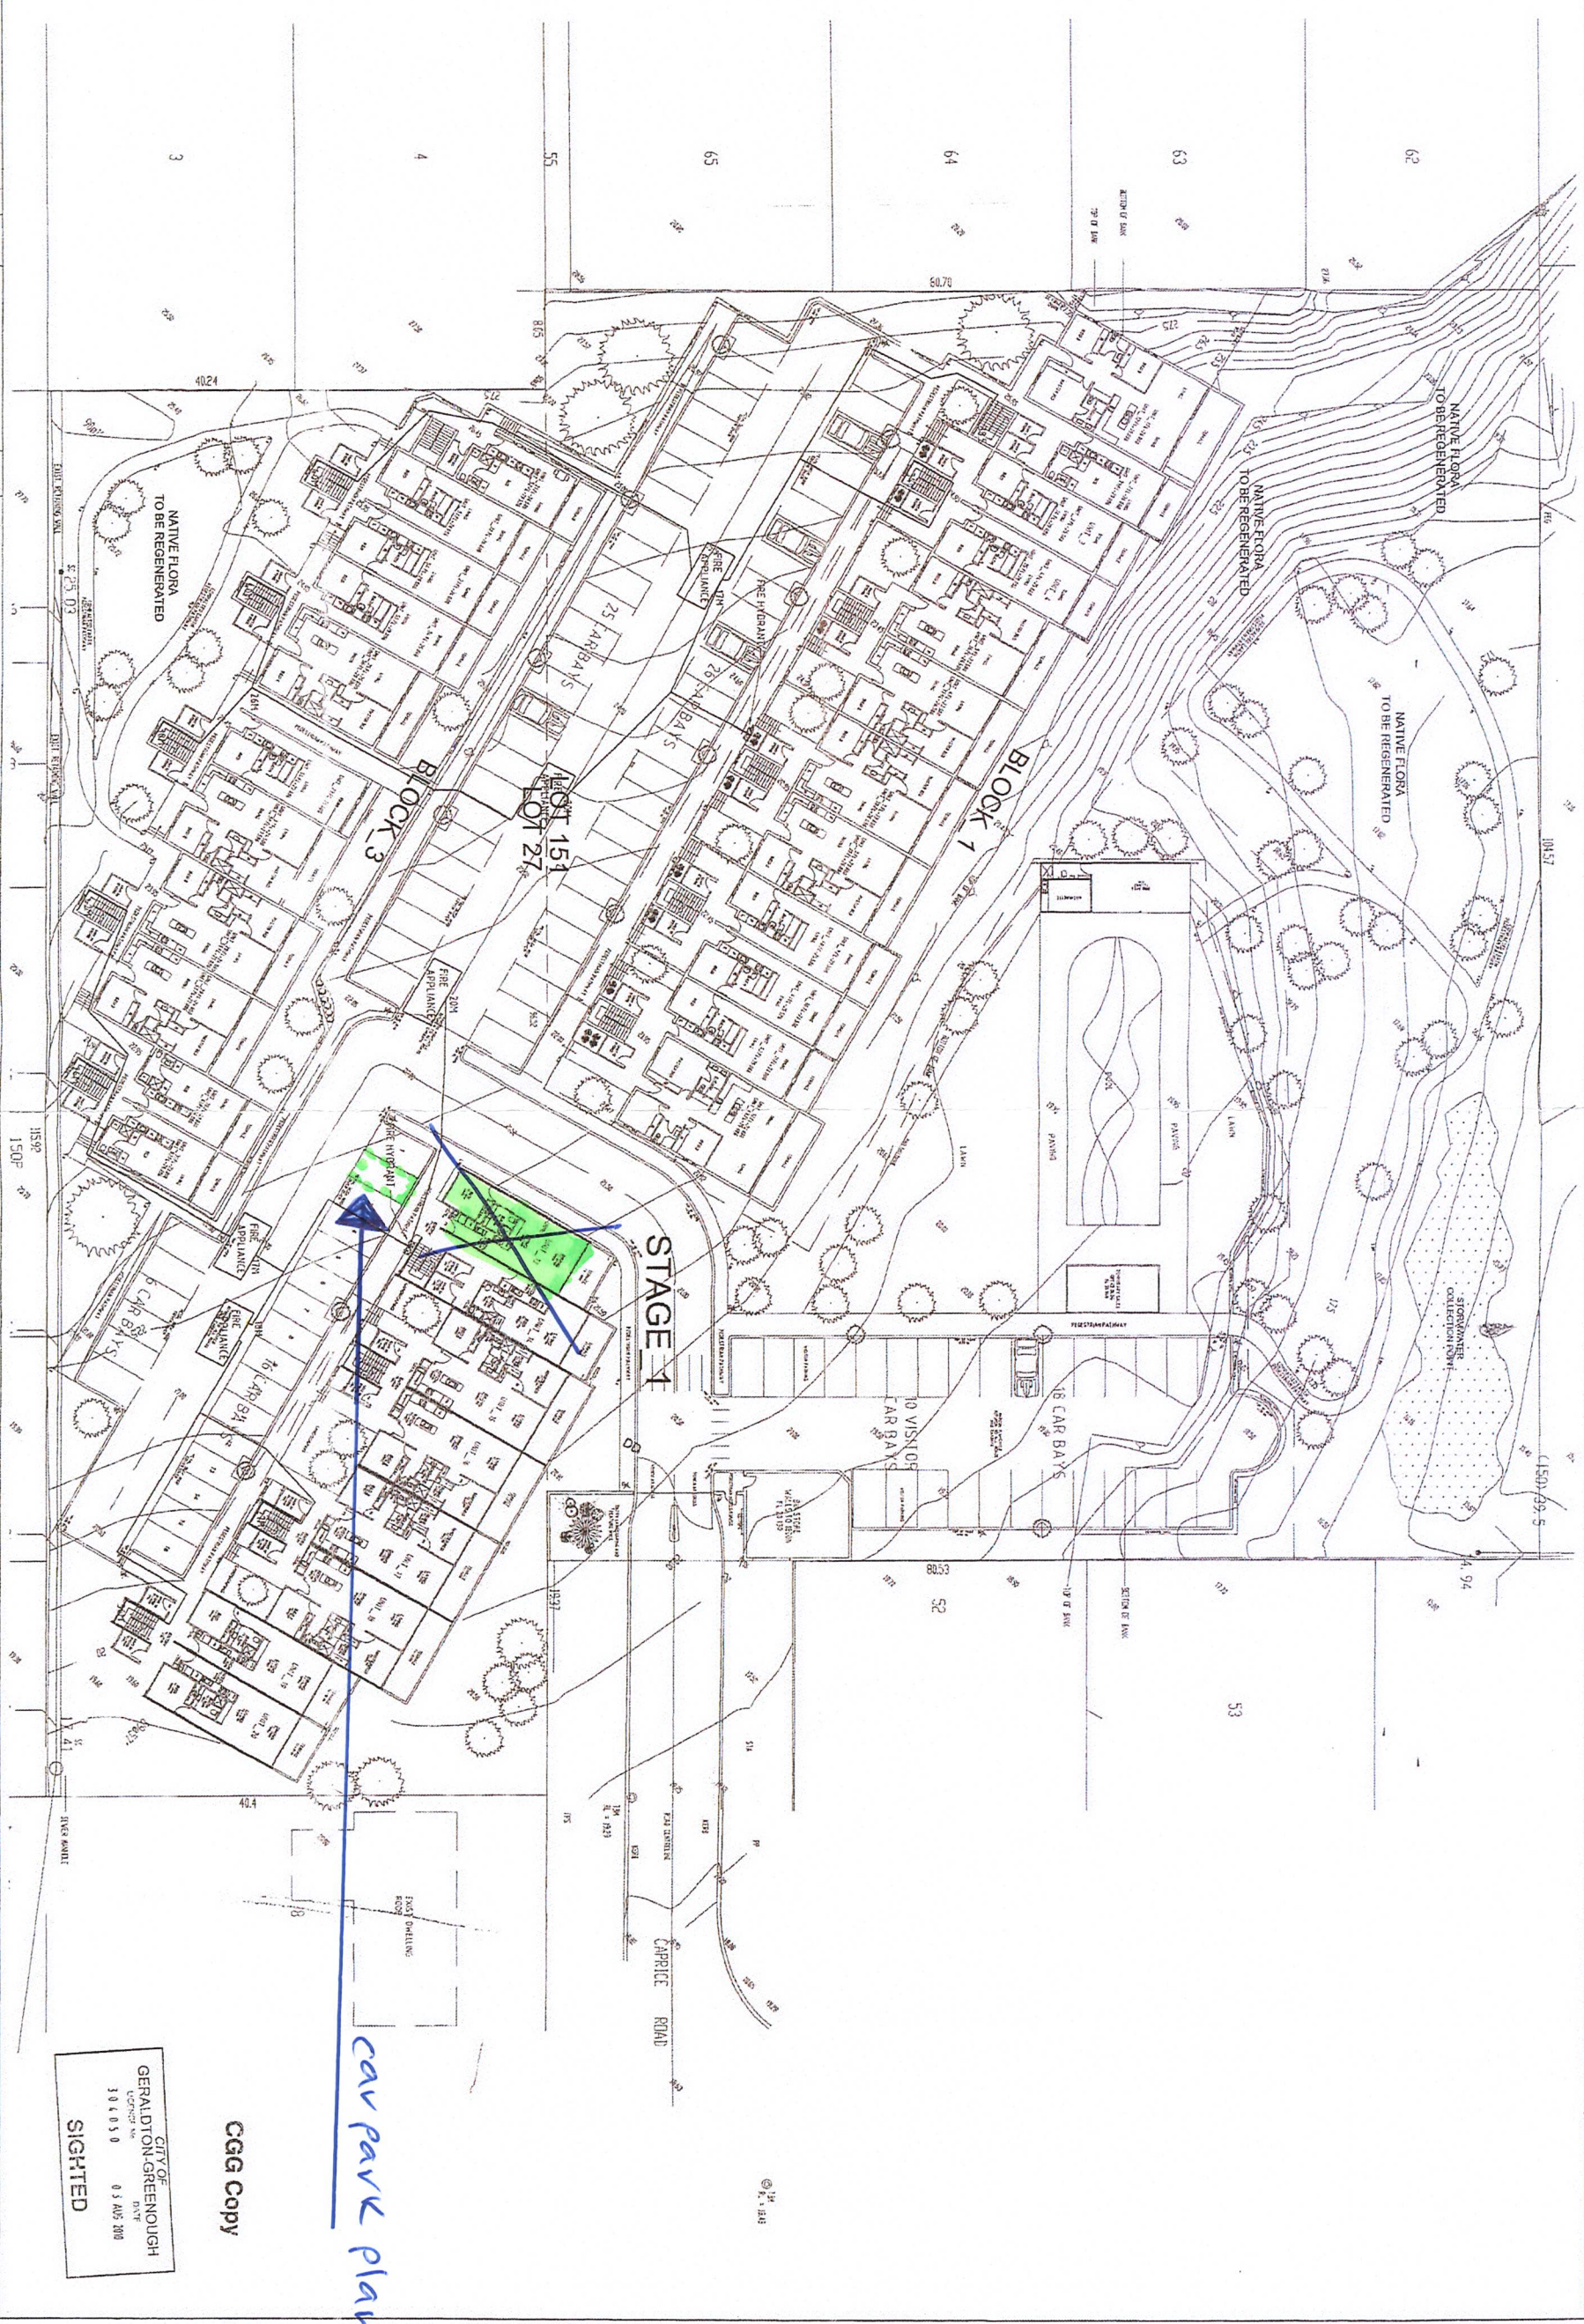

NO.	DATE:	AMENDMENT:	CHG.	NO.	DATE:	AMENDMENT:	CHG.
CONSULTANTS:				DESIGN AND DOCUMENTATION BY:			
STRUCTURAL:				ross mcdonald architects			
ELECTRICAL:				PTY LTD			
MECHANICAL:				ADDRESS: LOT 151 & 27 CAPRICORN RD, GERALDTON			
				CLIENT: WESTBEST PTY LTD			
				STAGE 1 SITE FIRE HOSE COVERAGE			
				DRAWN: DATE: 09/01/14			
				CHECKED: DATE: 09/01/14			
				SCALE: 1:250			
				ISSUED FOR: BL			
				DATE: 09/01/14			
				FILE NAME: DATE: 09/01/14			
				THIS IS A CAD DRAWING AND NOT A PHOTOGRAPH			